




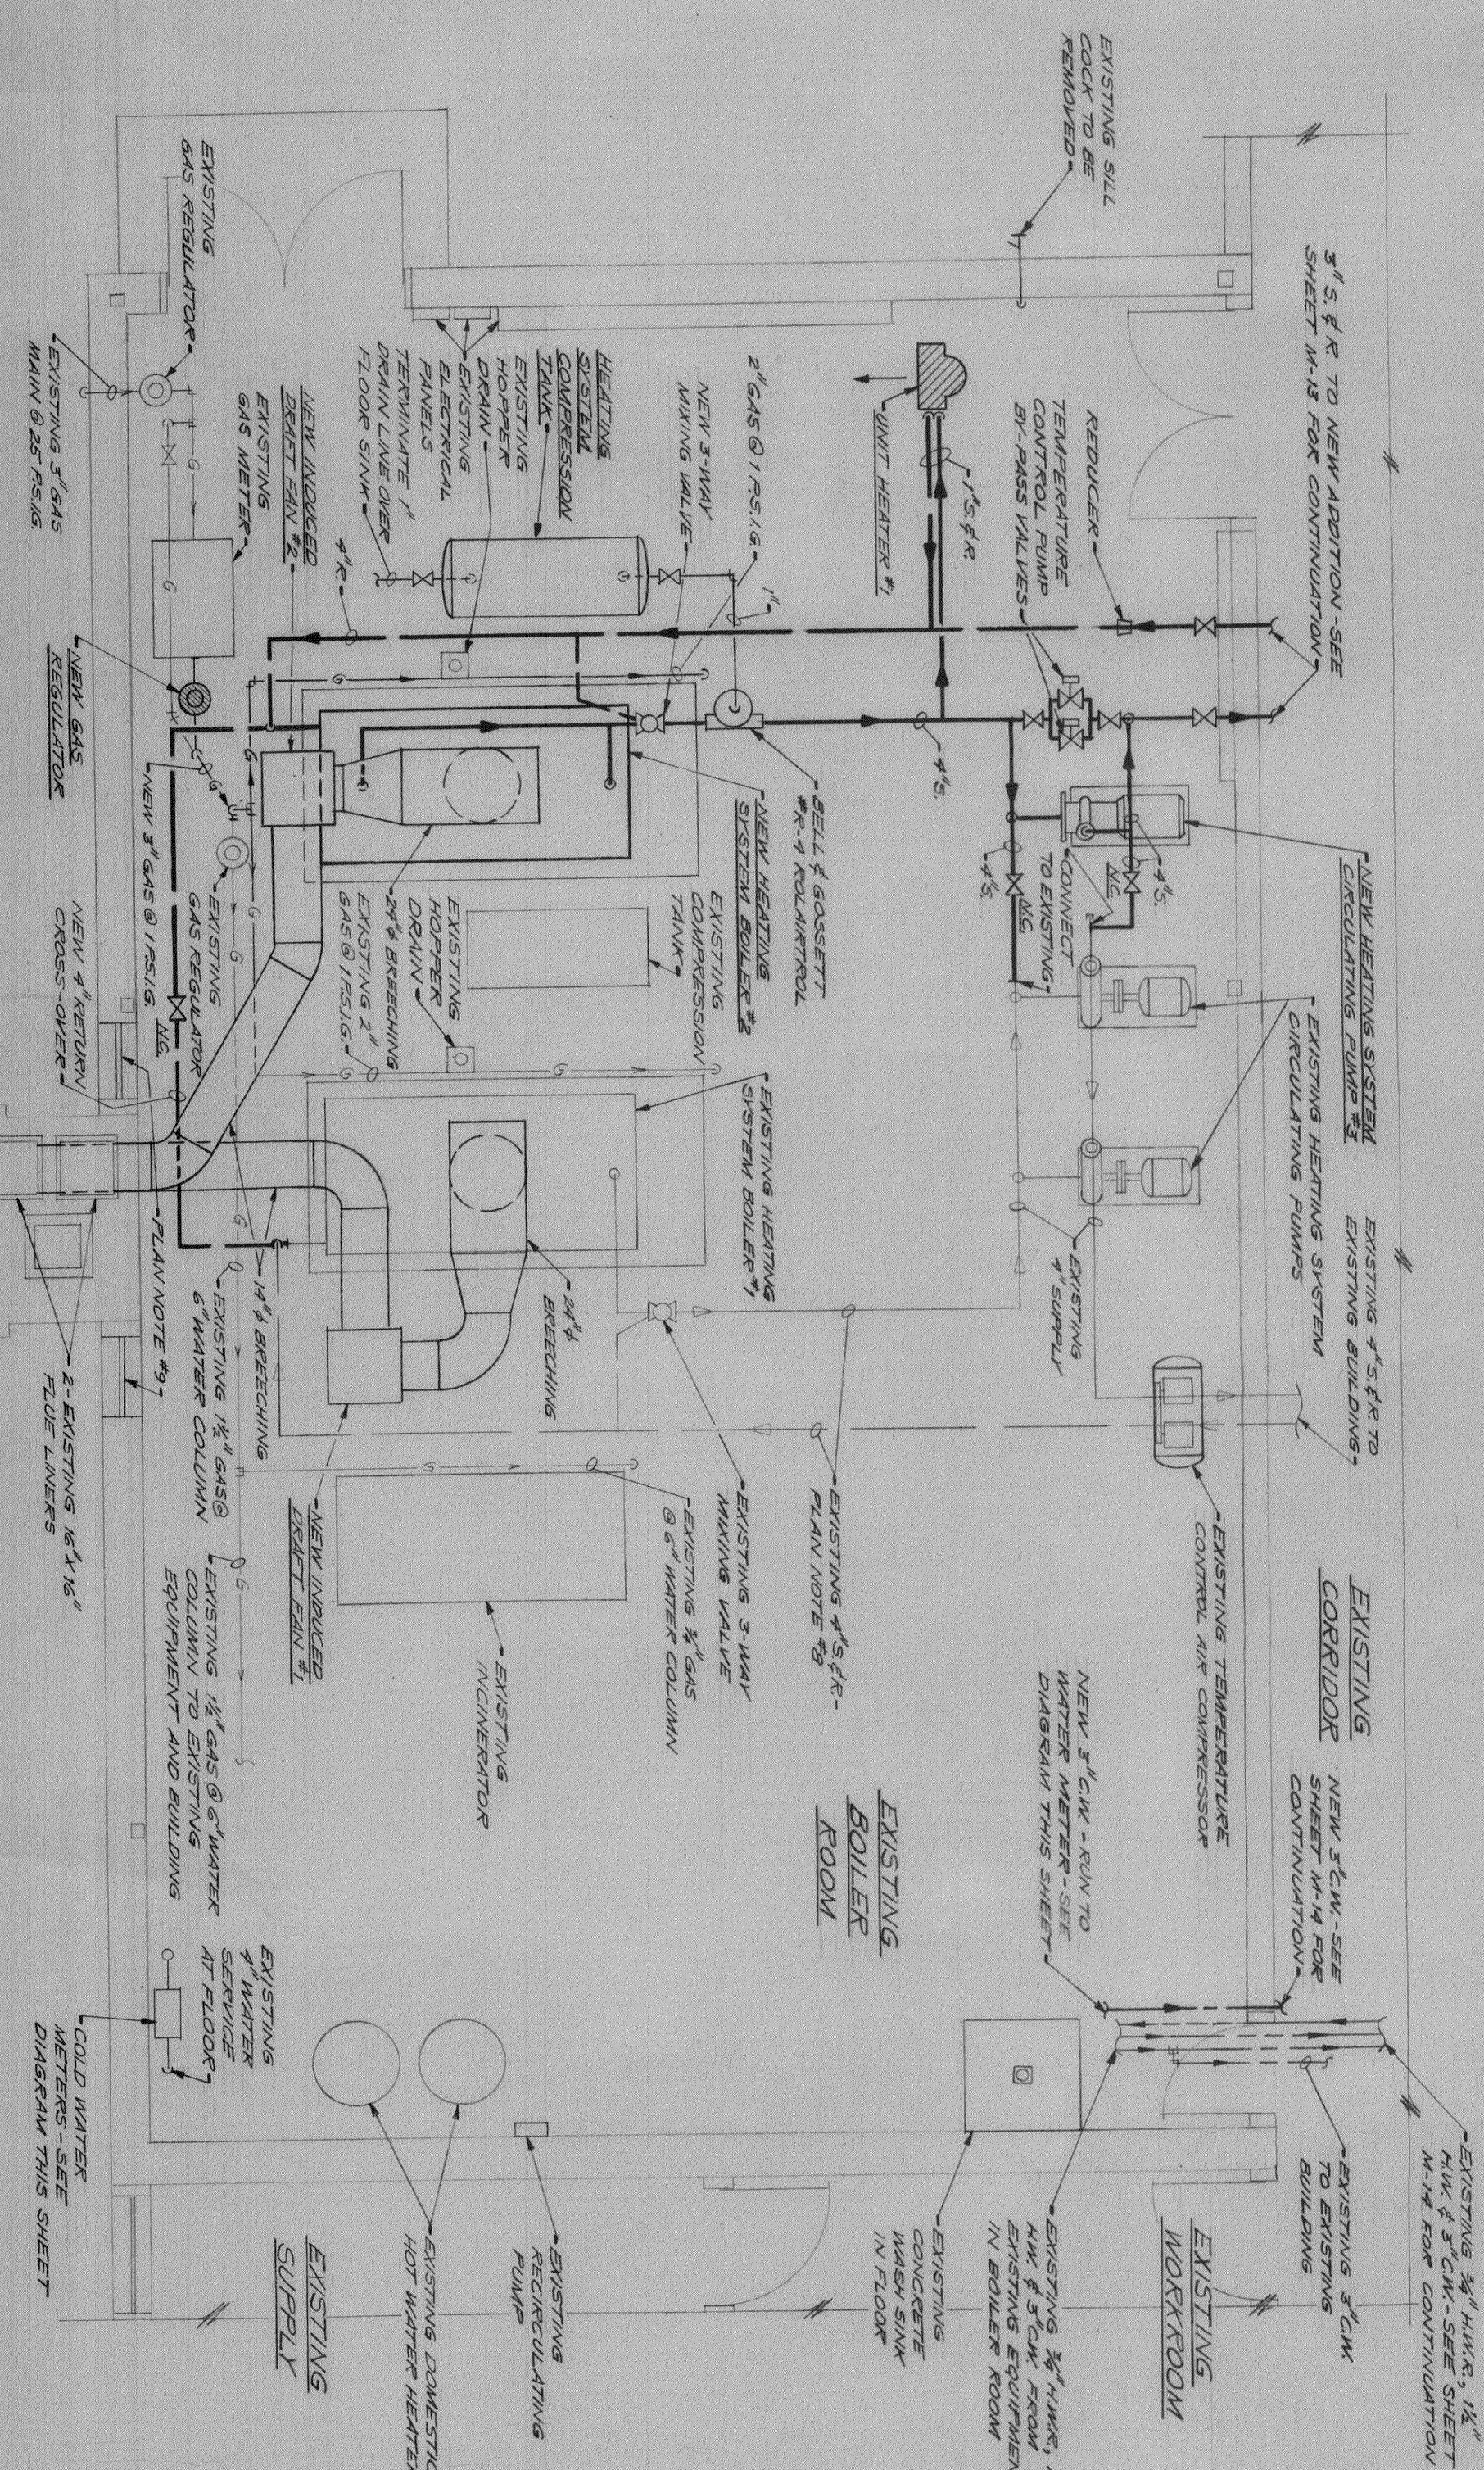

EXISTING BOILER ROOM LAYOUT
SCALE 1/4" = 1'-0"

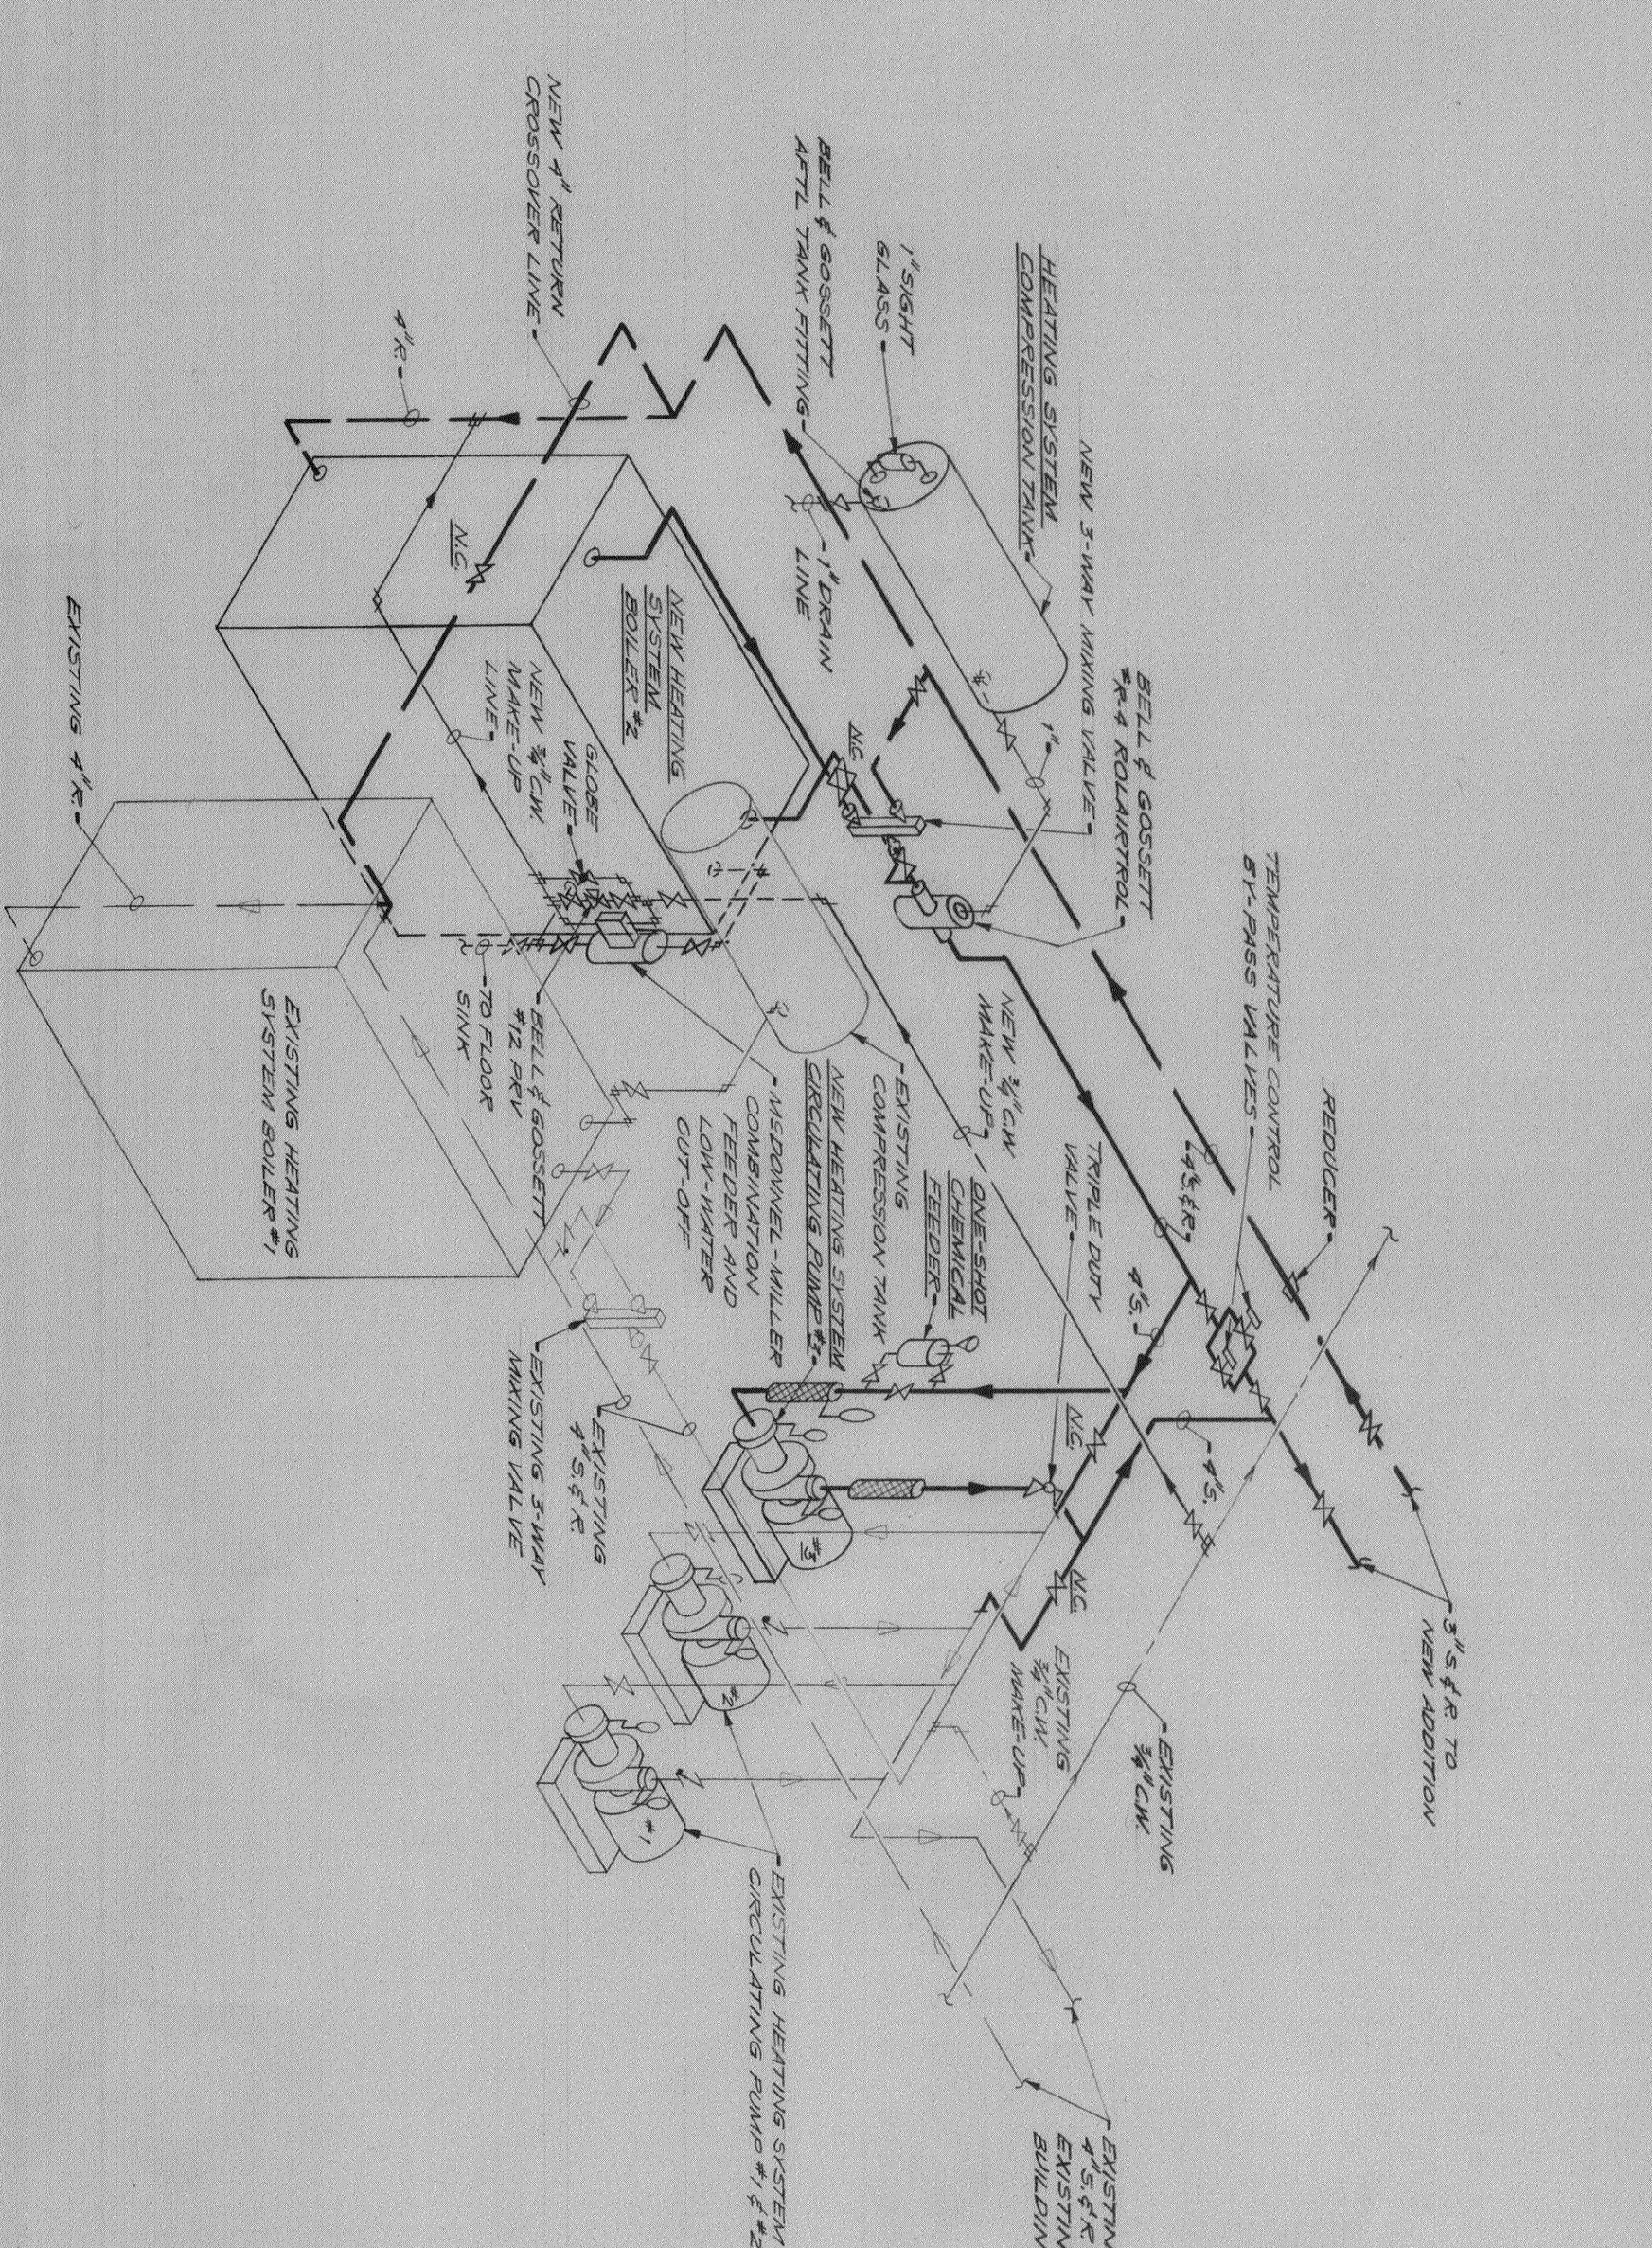

HEATING SYSTEM PIPING SCHEMATIC
NO SCALE

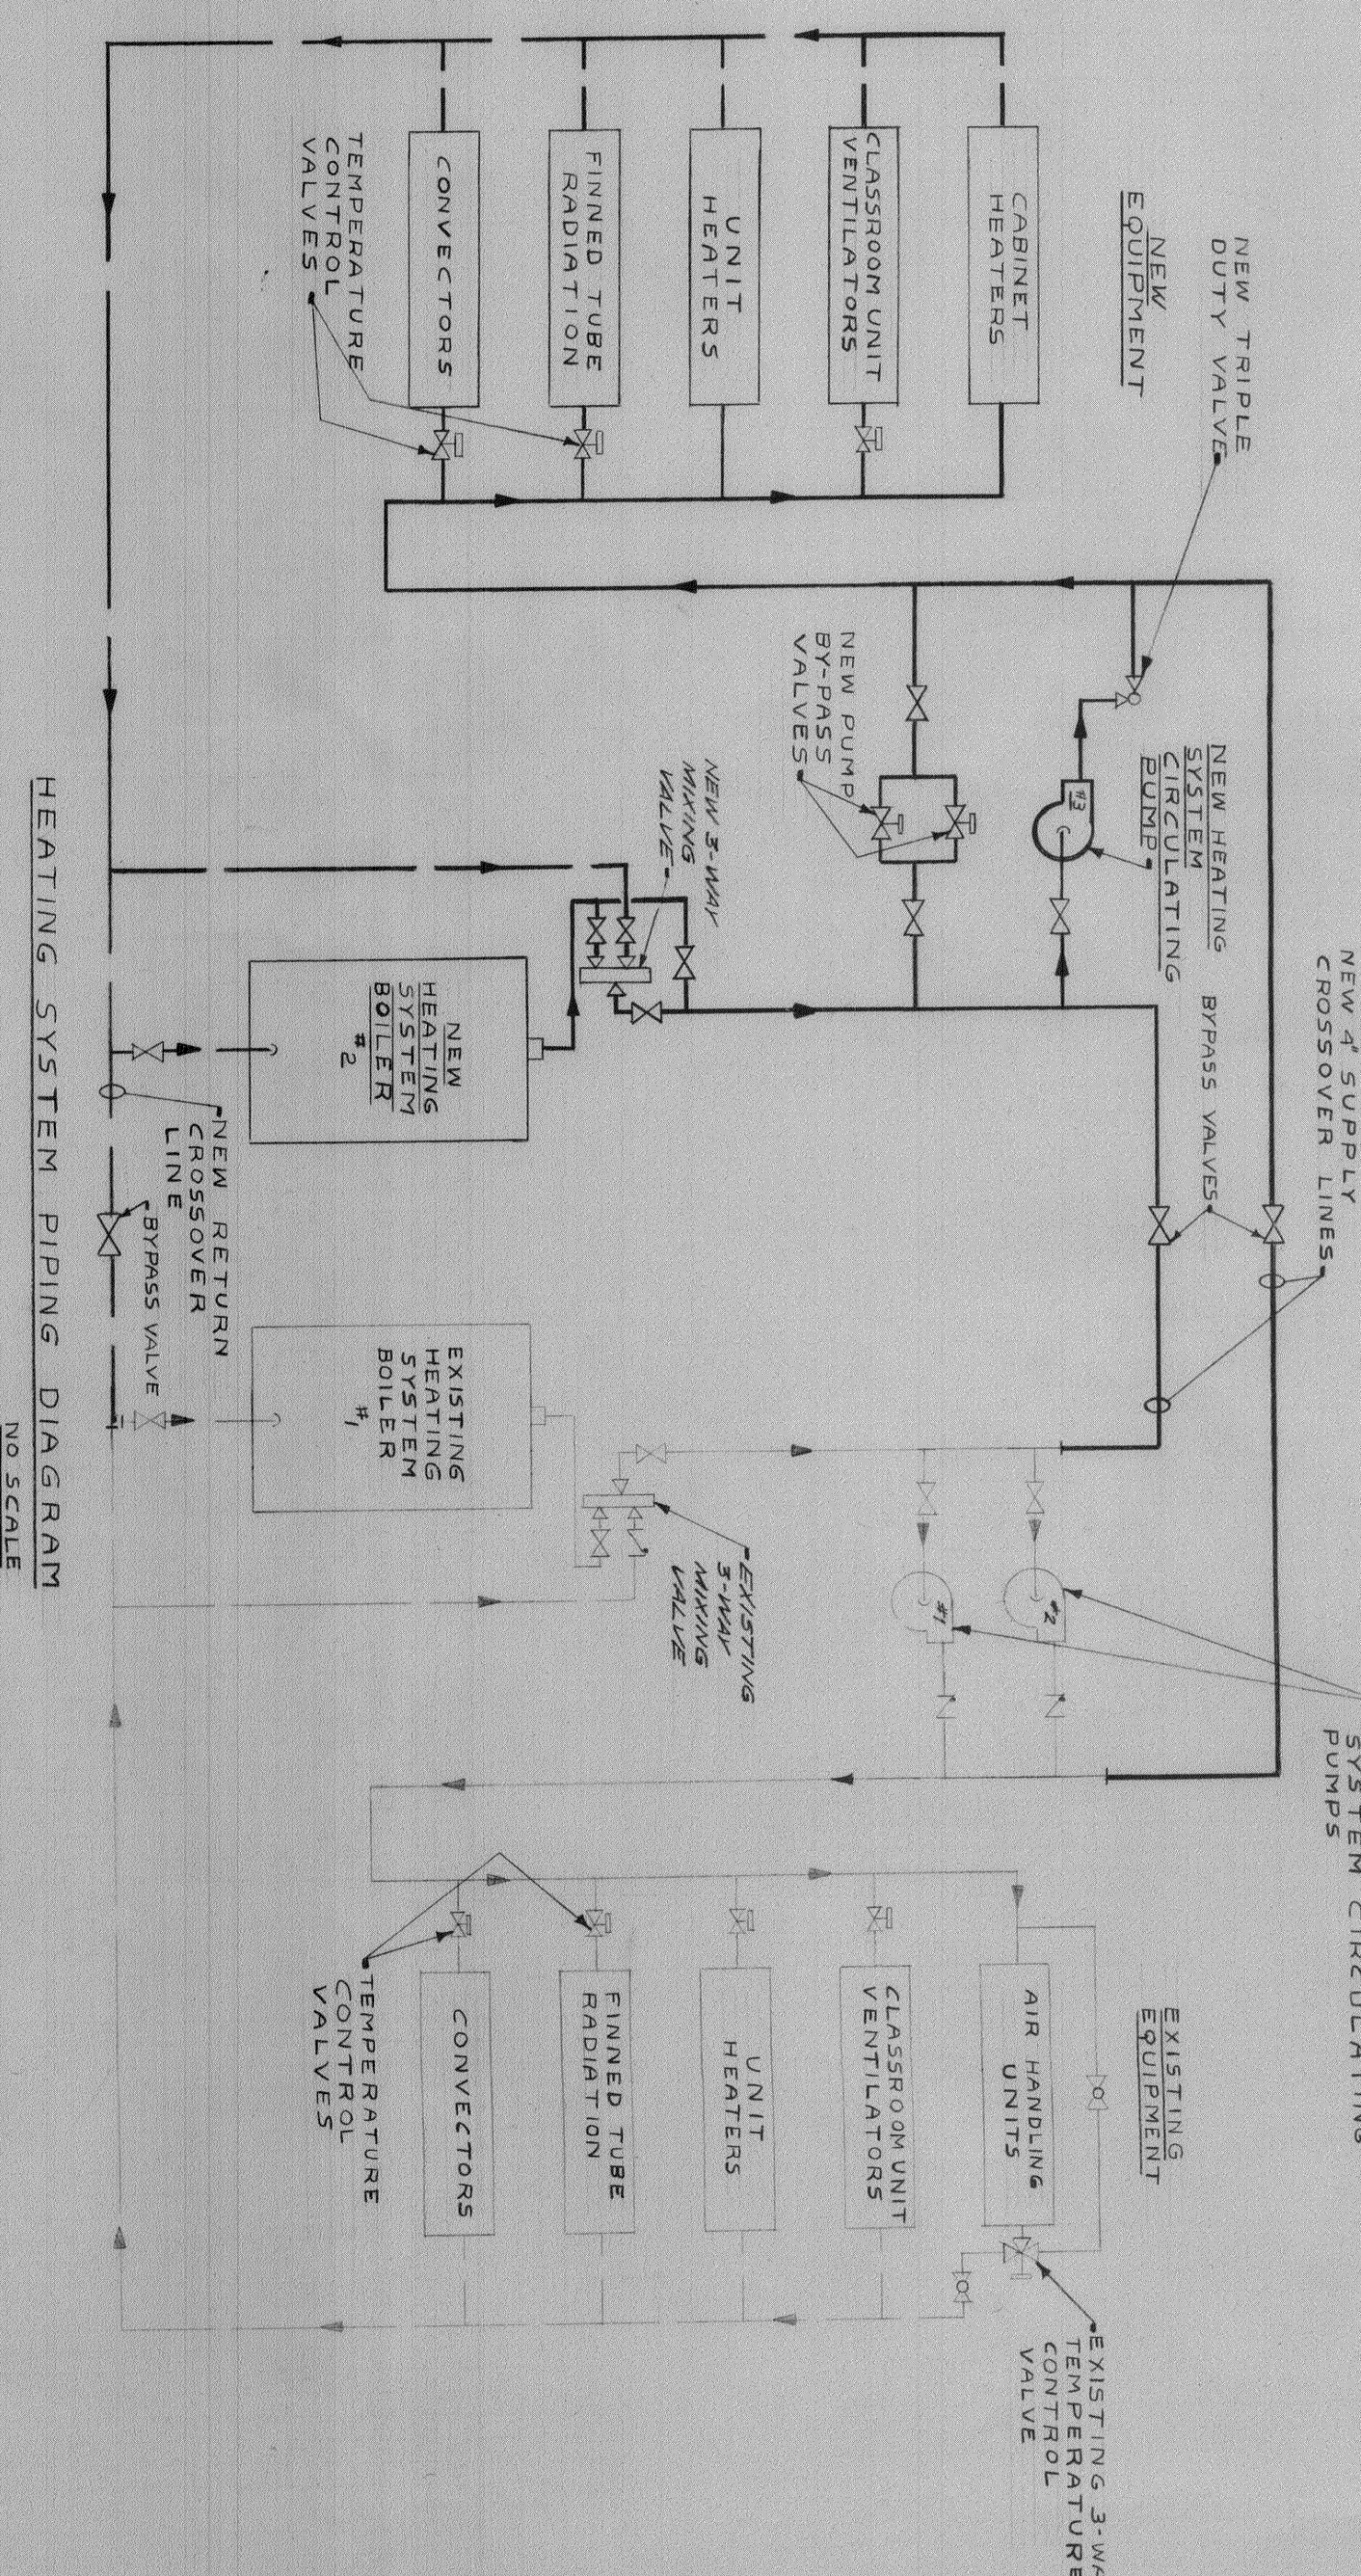

HEATING SYSTEM PIPING DIAGRAM
NO SCALE

1. MECHANICAL CONTRACTOR SHALL VERIFY LOCATION AND ELEVATION OF EXISTING LINE BEFORE CONNECTING TO NEW LINE.

PLAN NOTES



BOILER ROOM PLAN NOTES

- [illegible]



MECHANICAL EQUIPMENT SCHEDULE

- [illegible]

SERVICE THIRD FLOOR
COLD WATER METER
PIPING DIAGRAM
NO. 5544

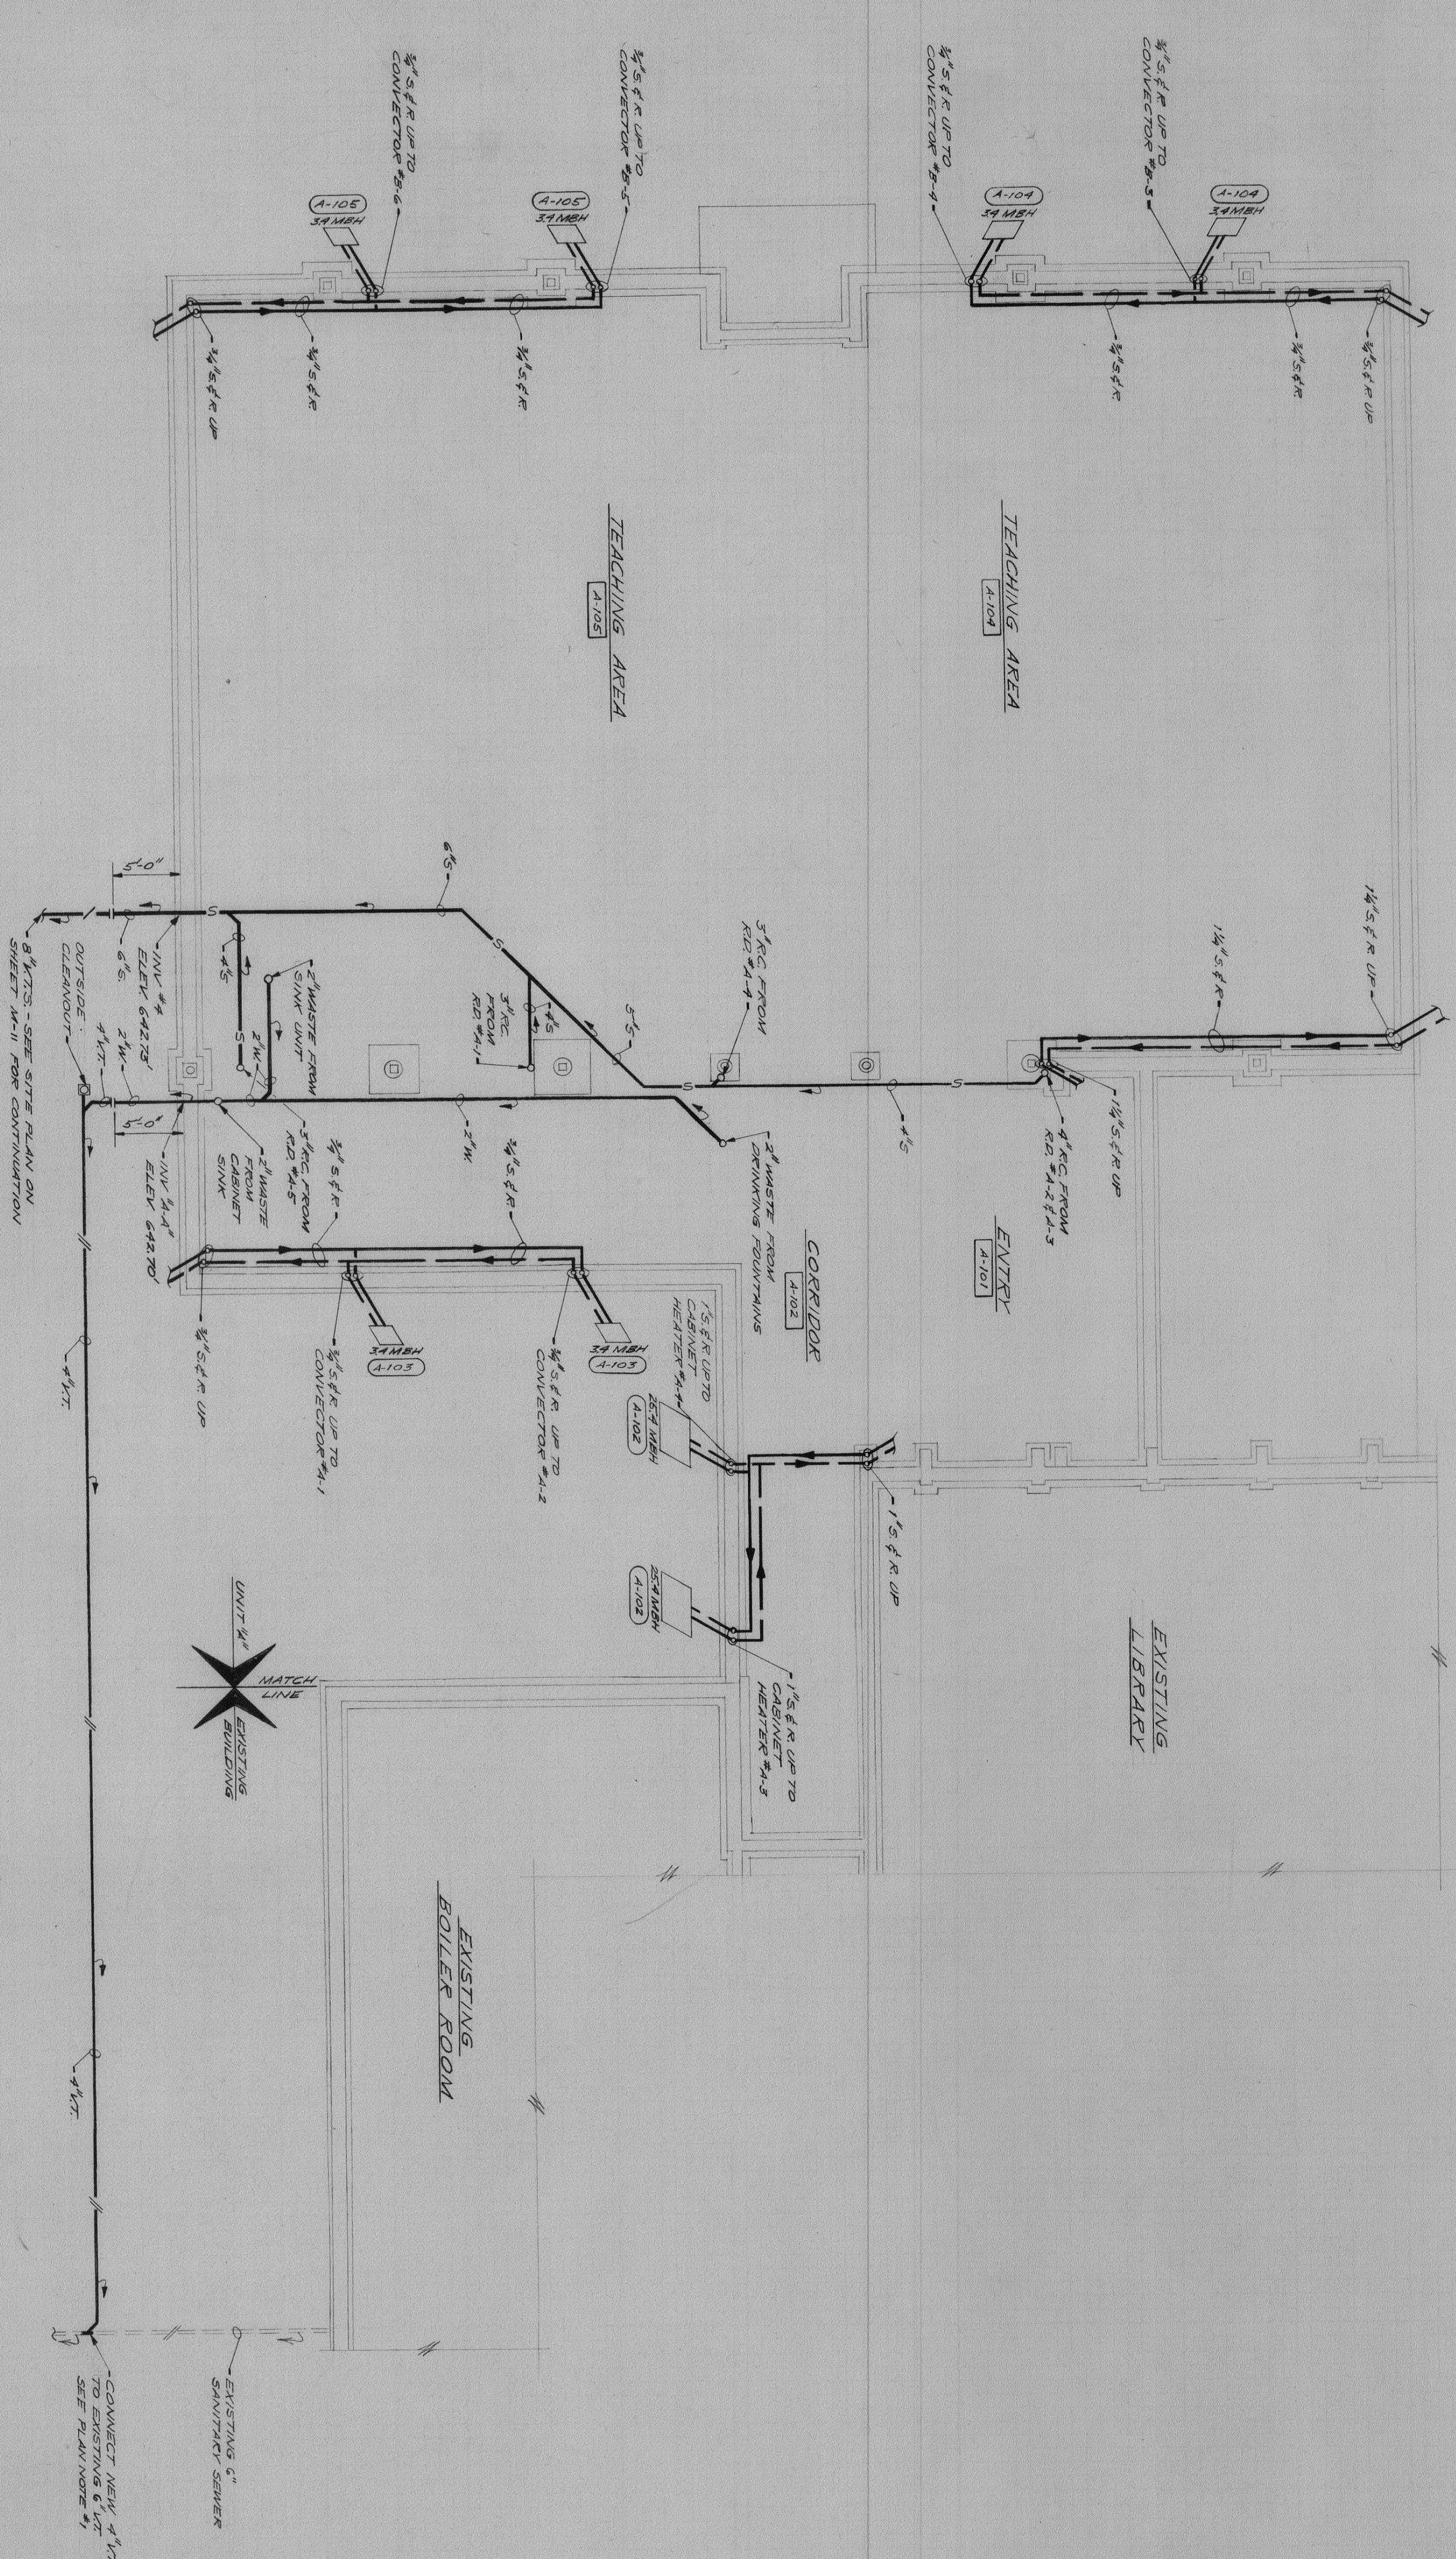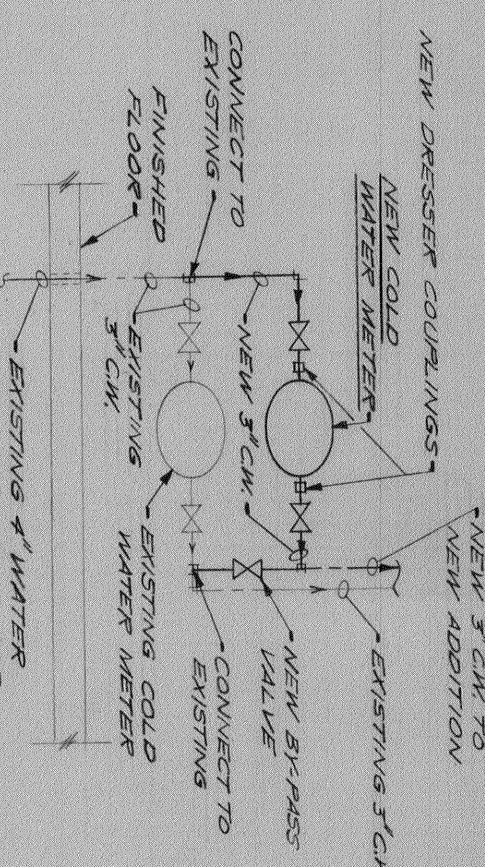

UNIT "A" HEATING, VENTILATING AND PLUMBING FOUNDATION PLAN

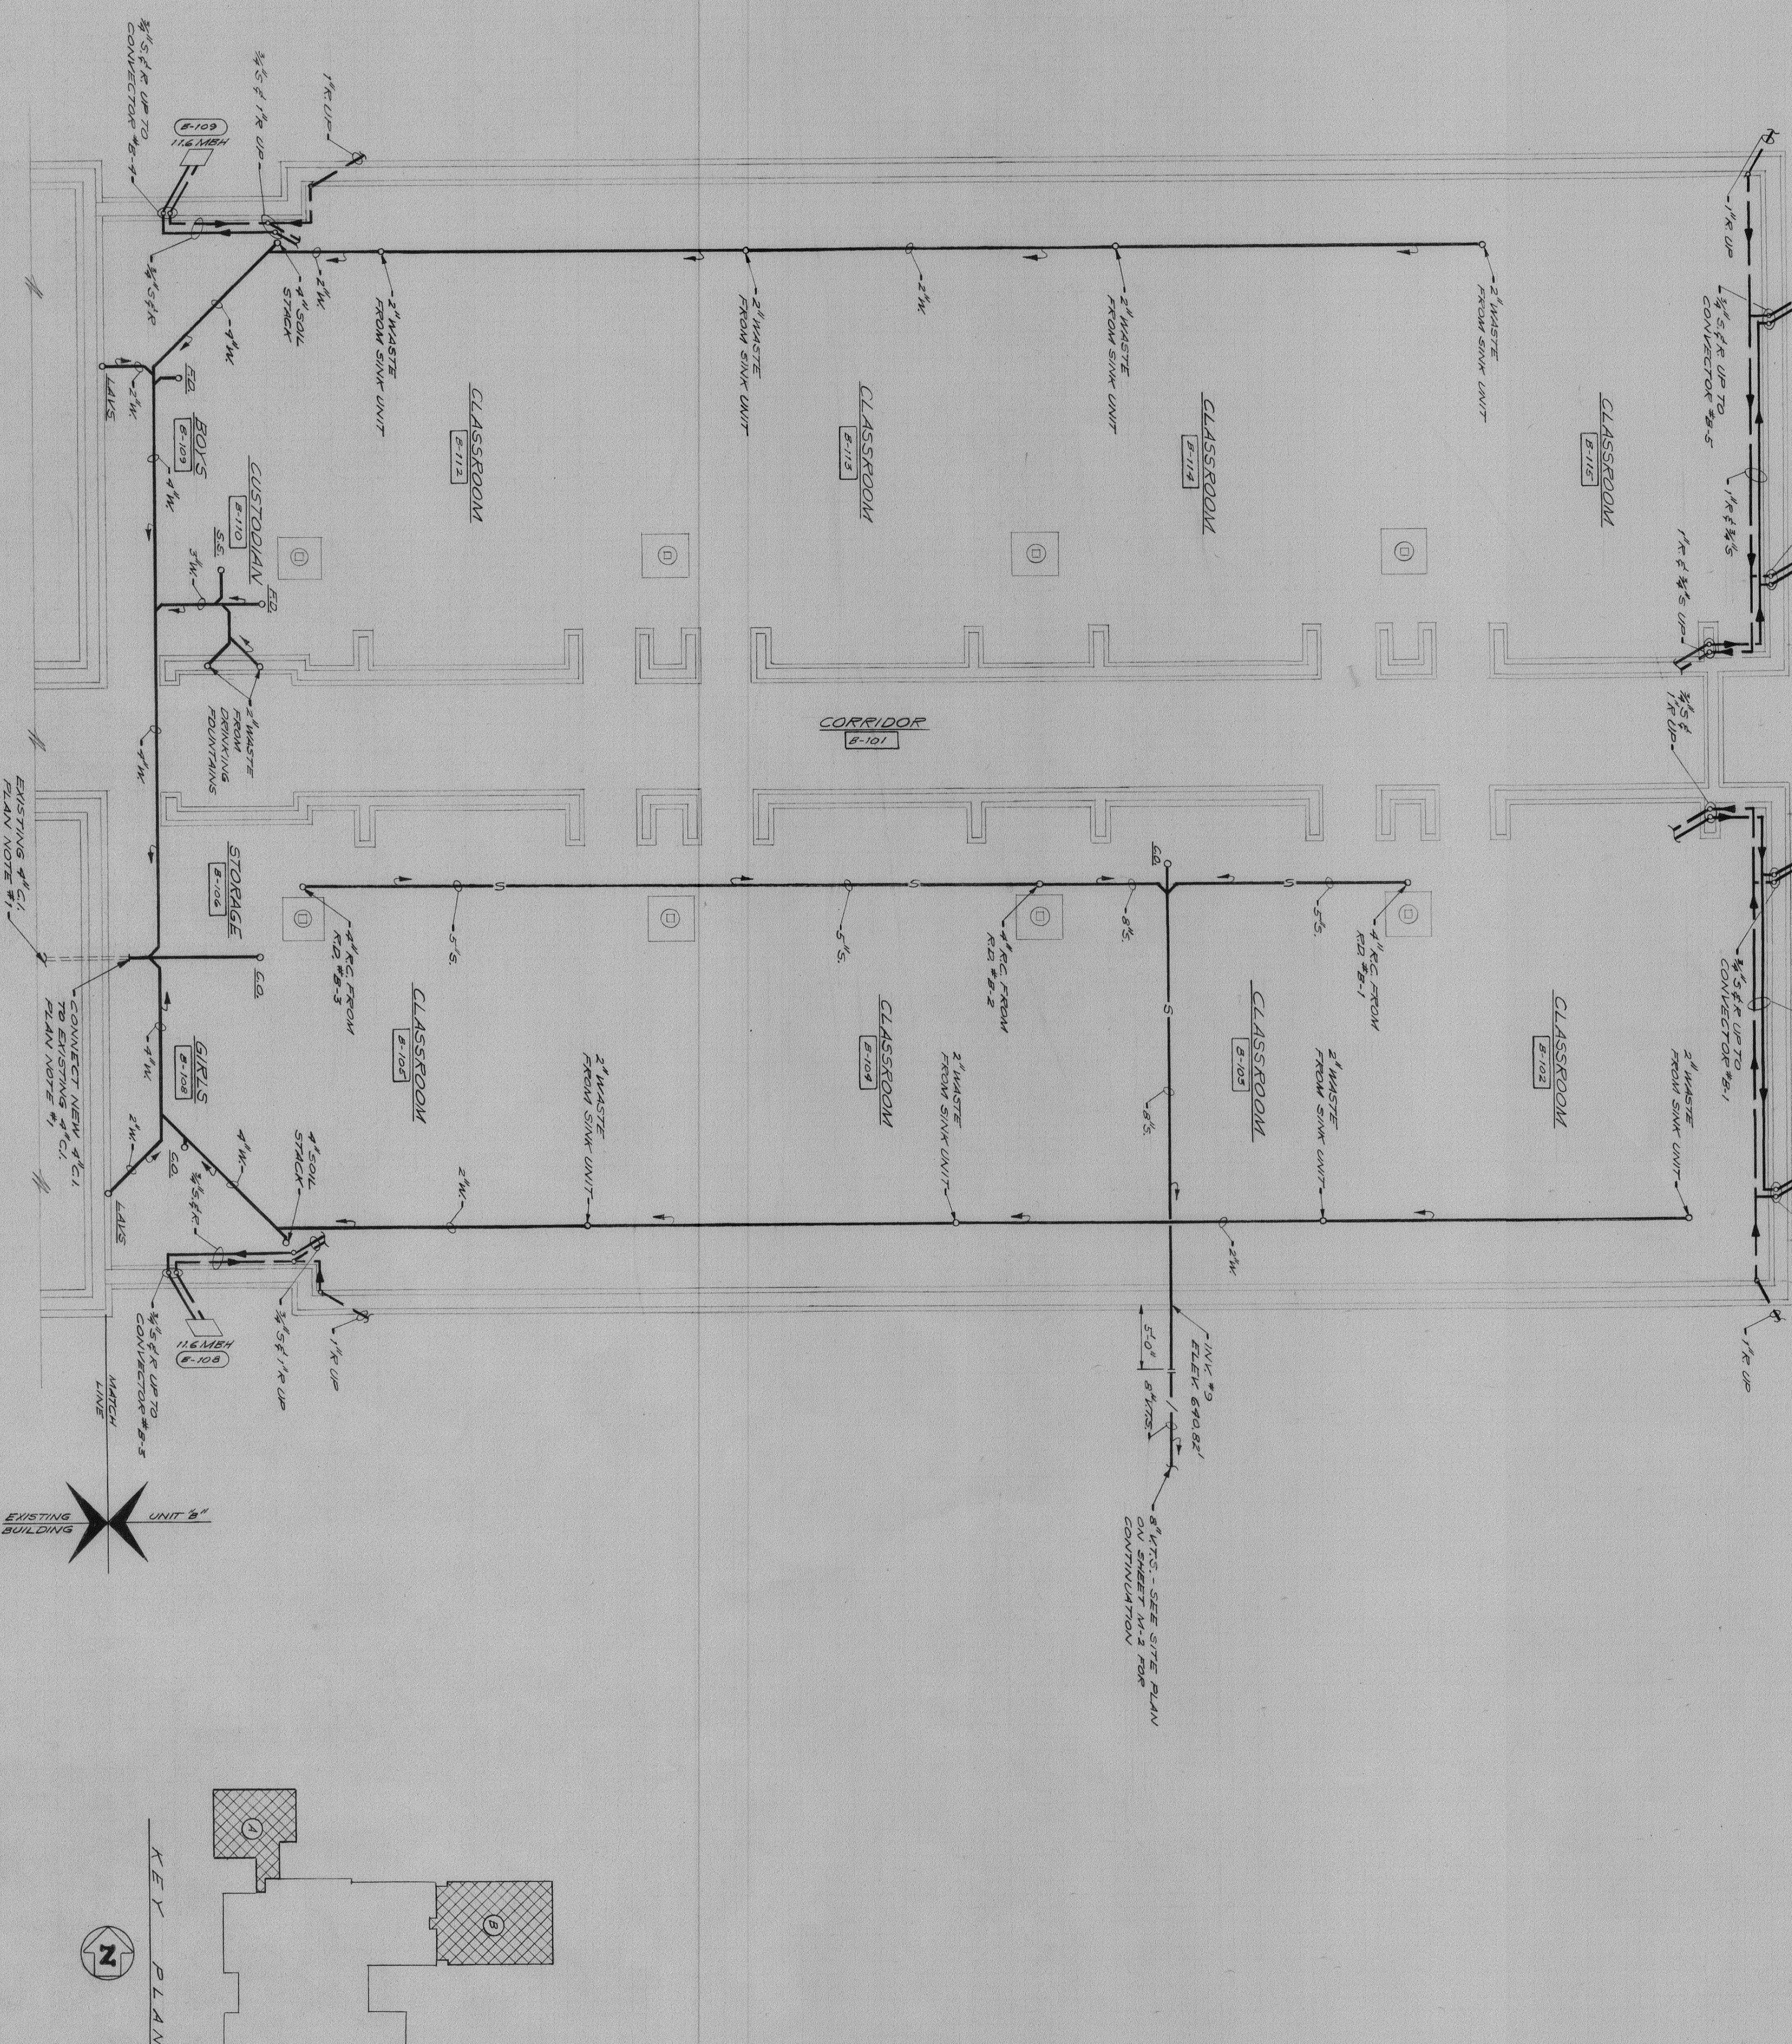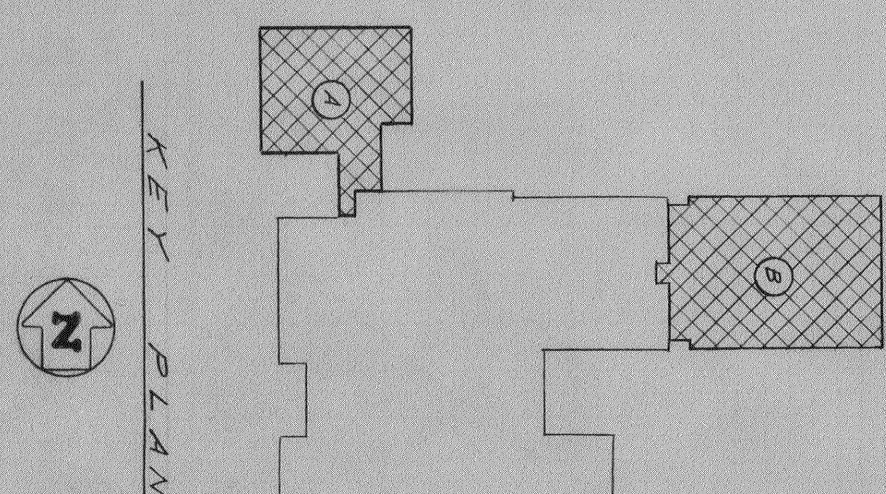UNIT 'B' HEATING, VENTILATING AND PLUMBING FOUNDATION PLAN
SCALE: 1/8" = 1'-0"

PLAN